

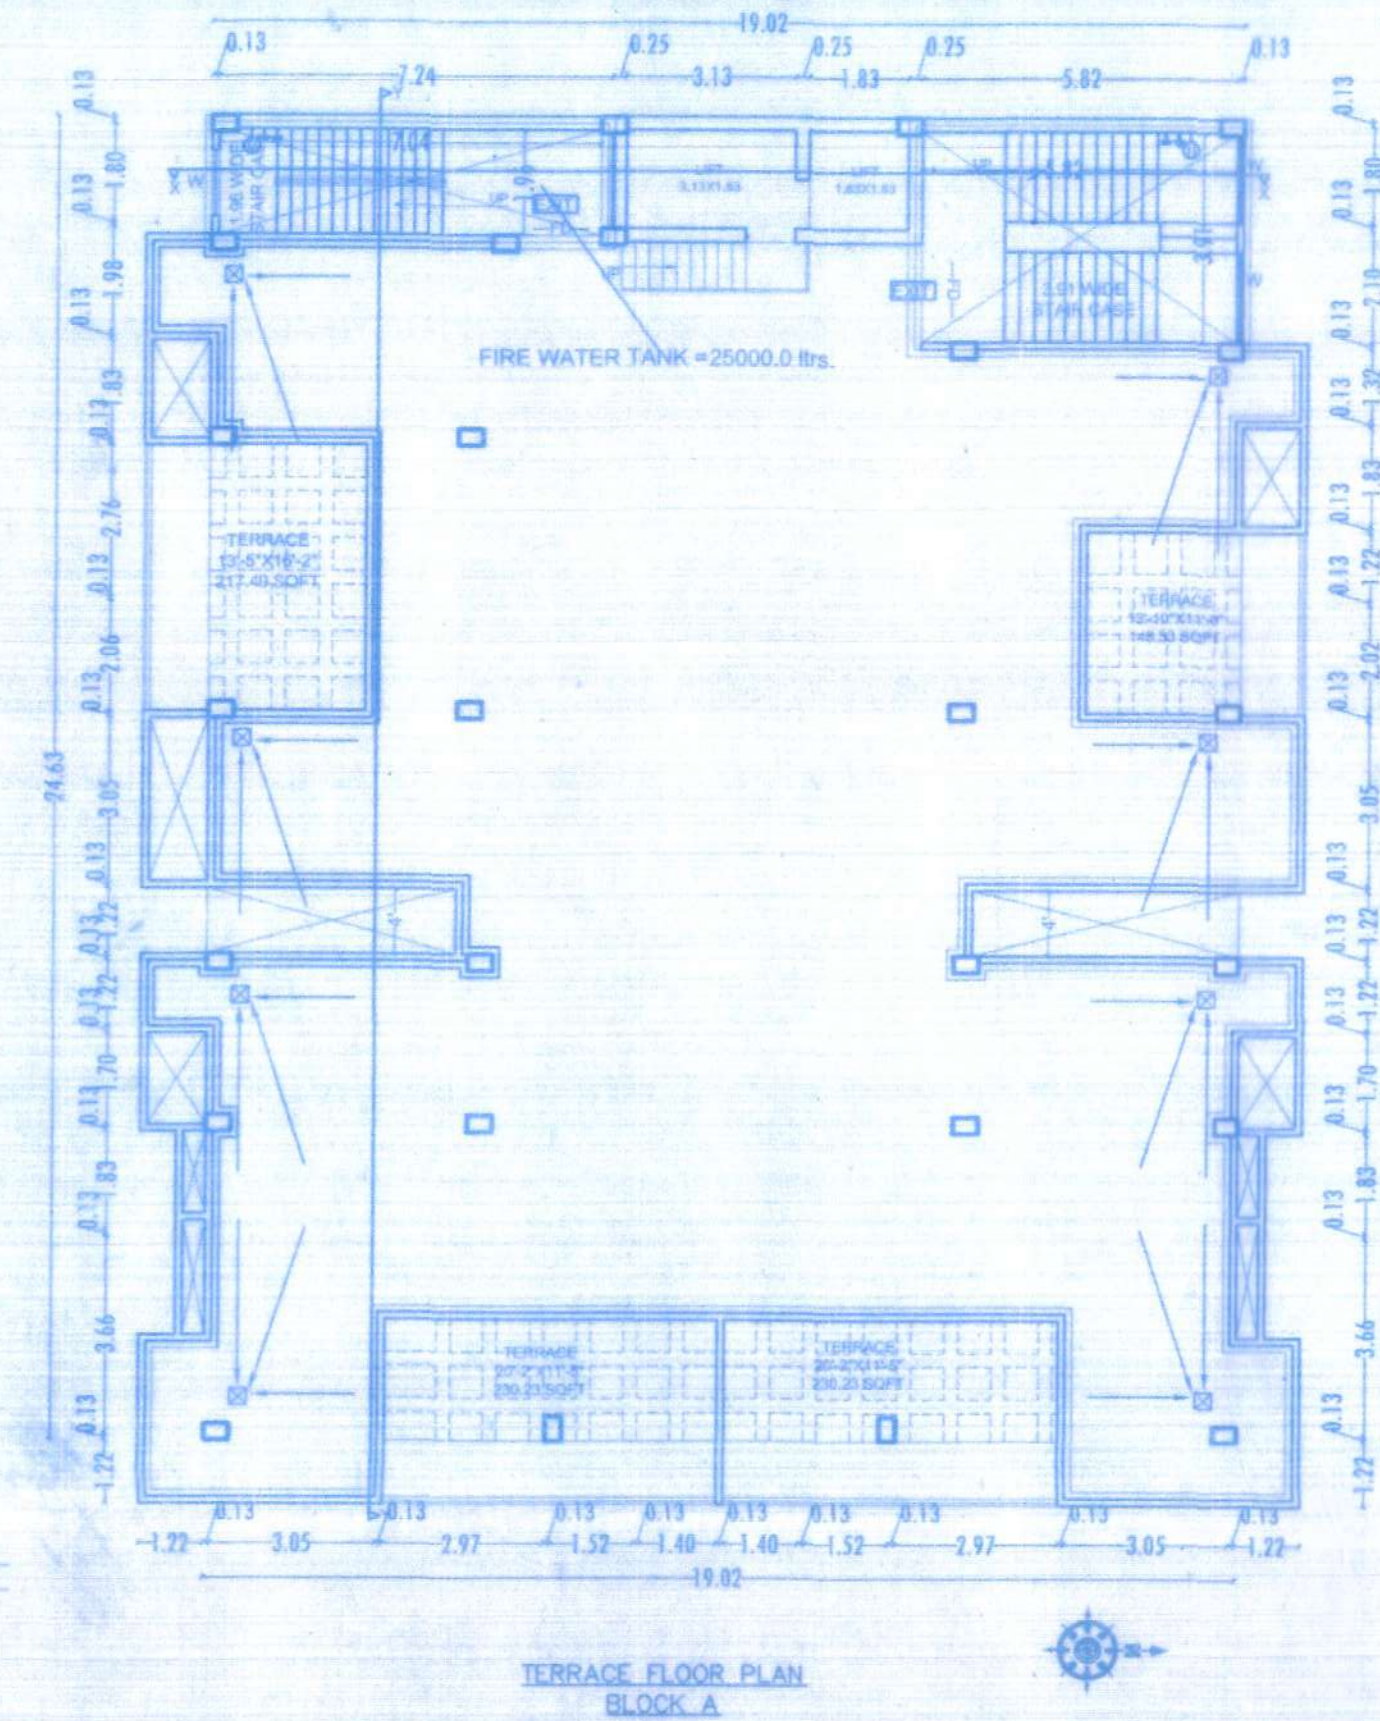
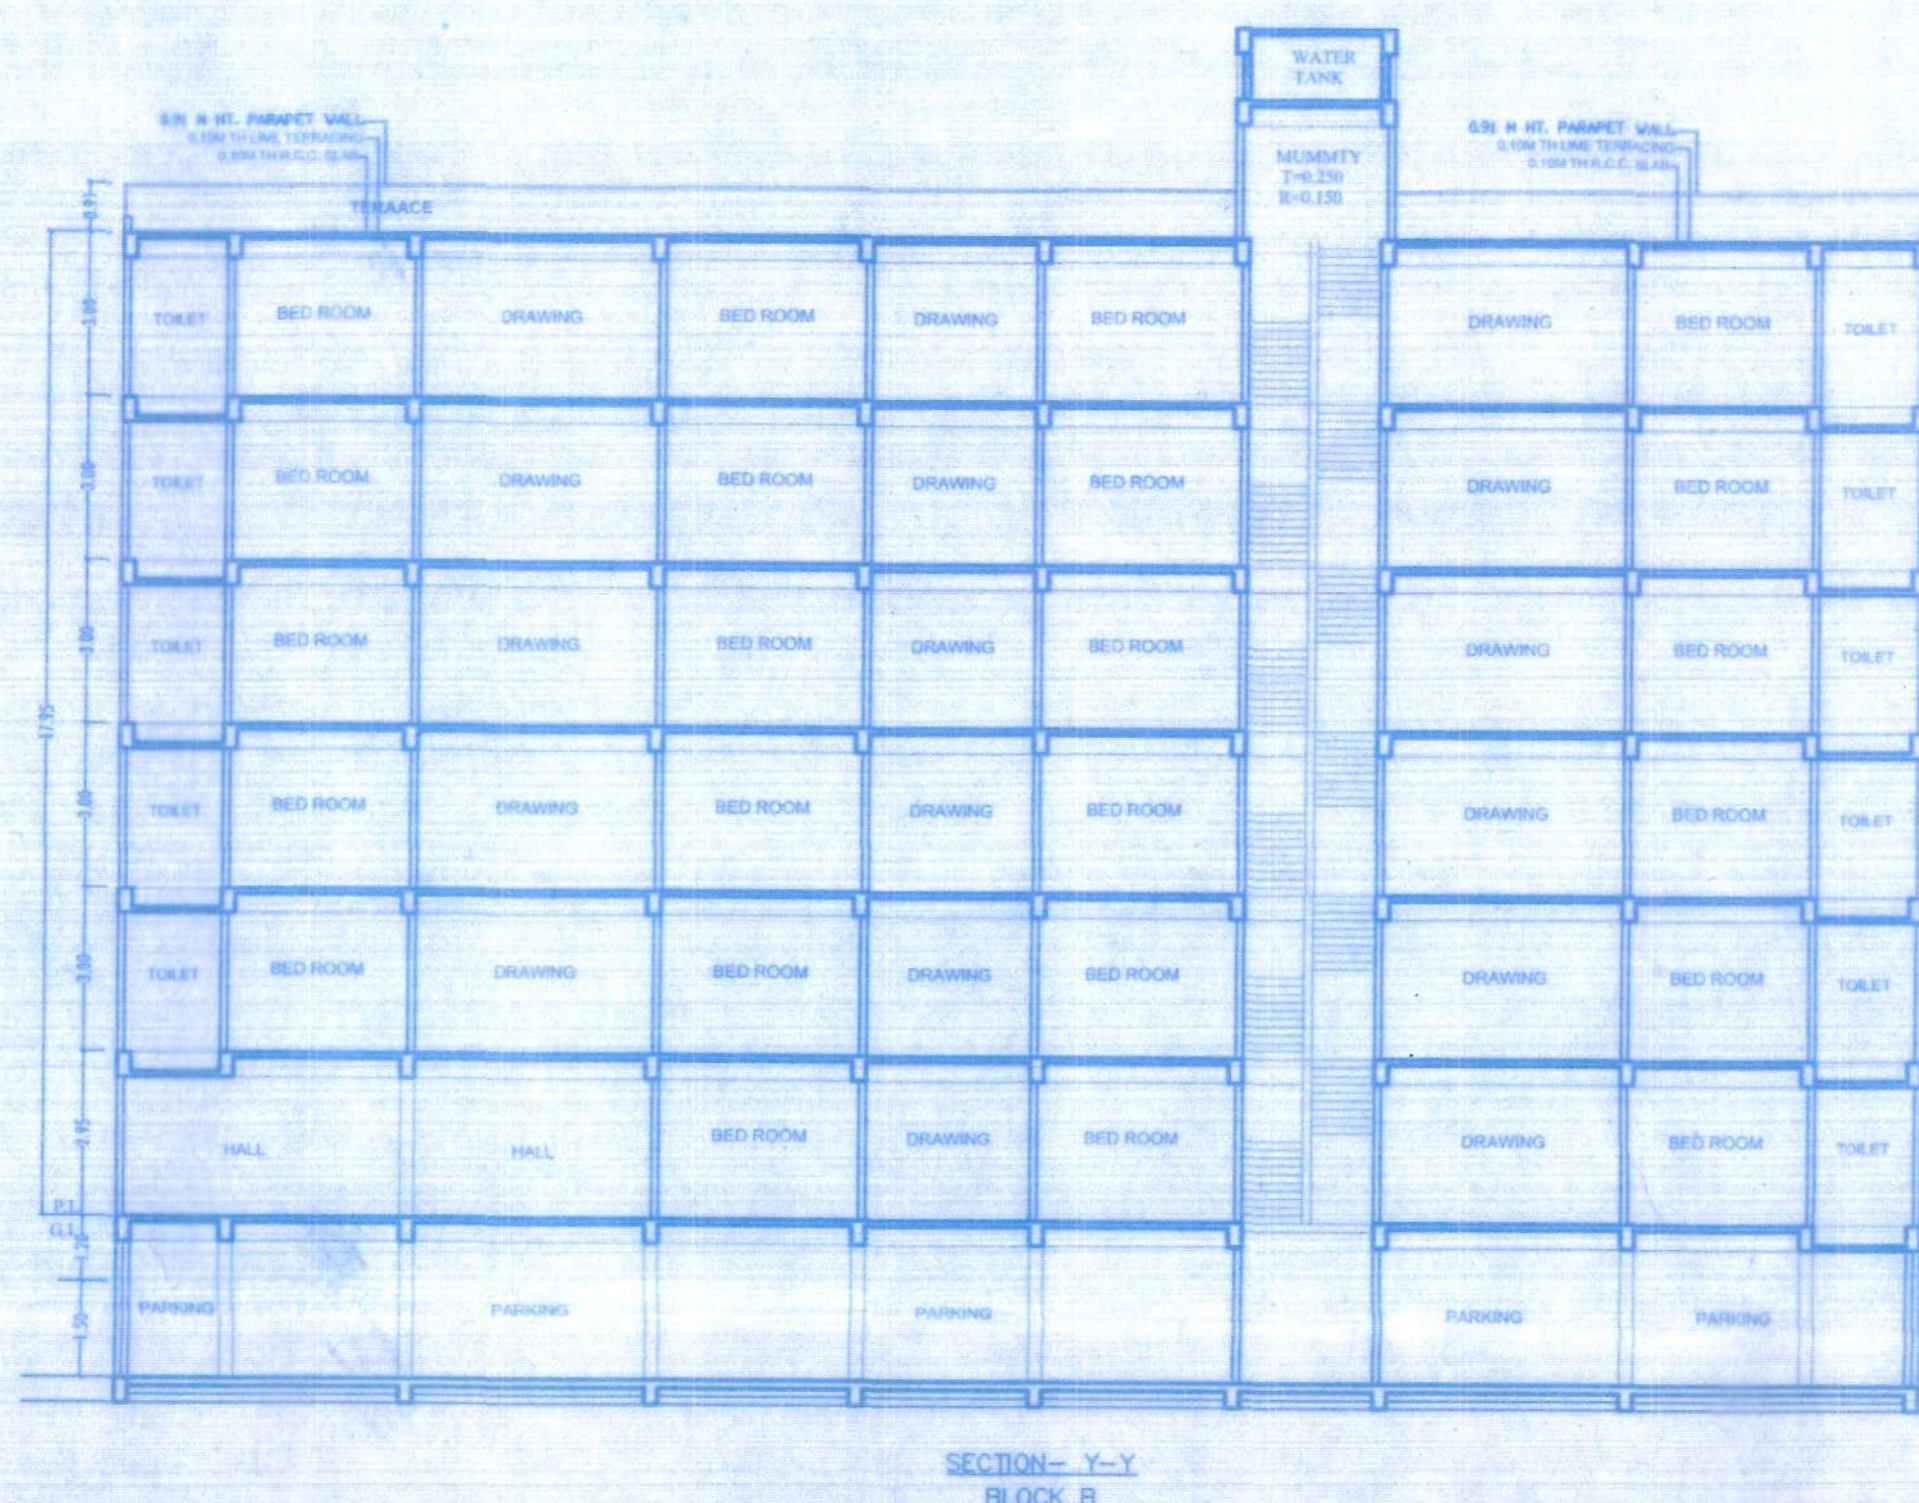


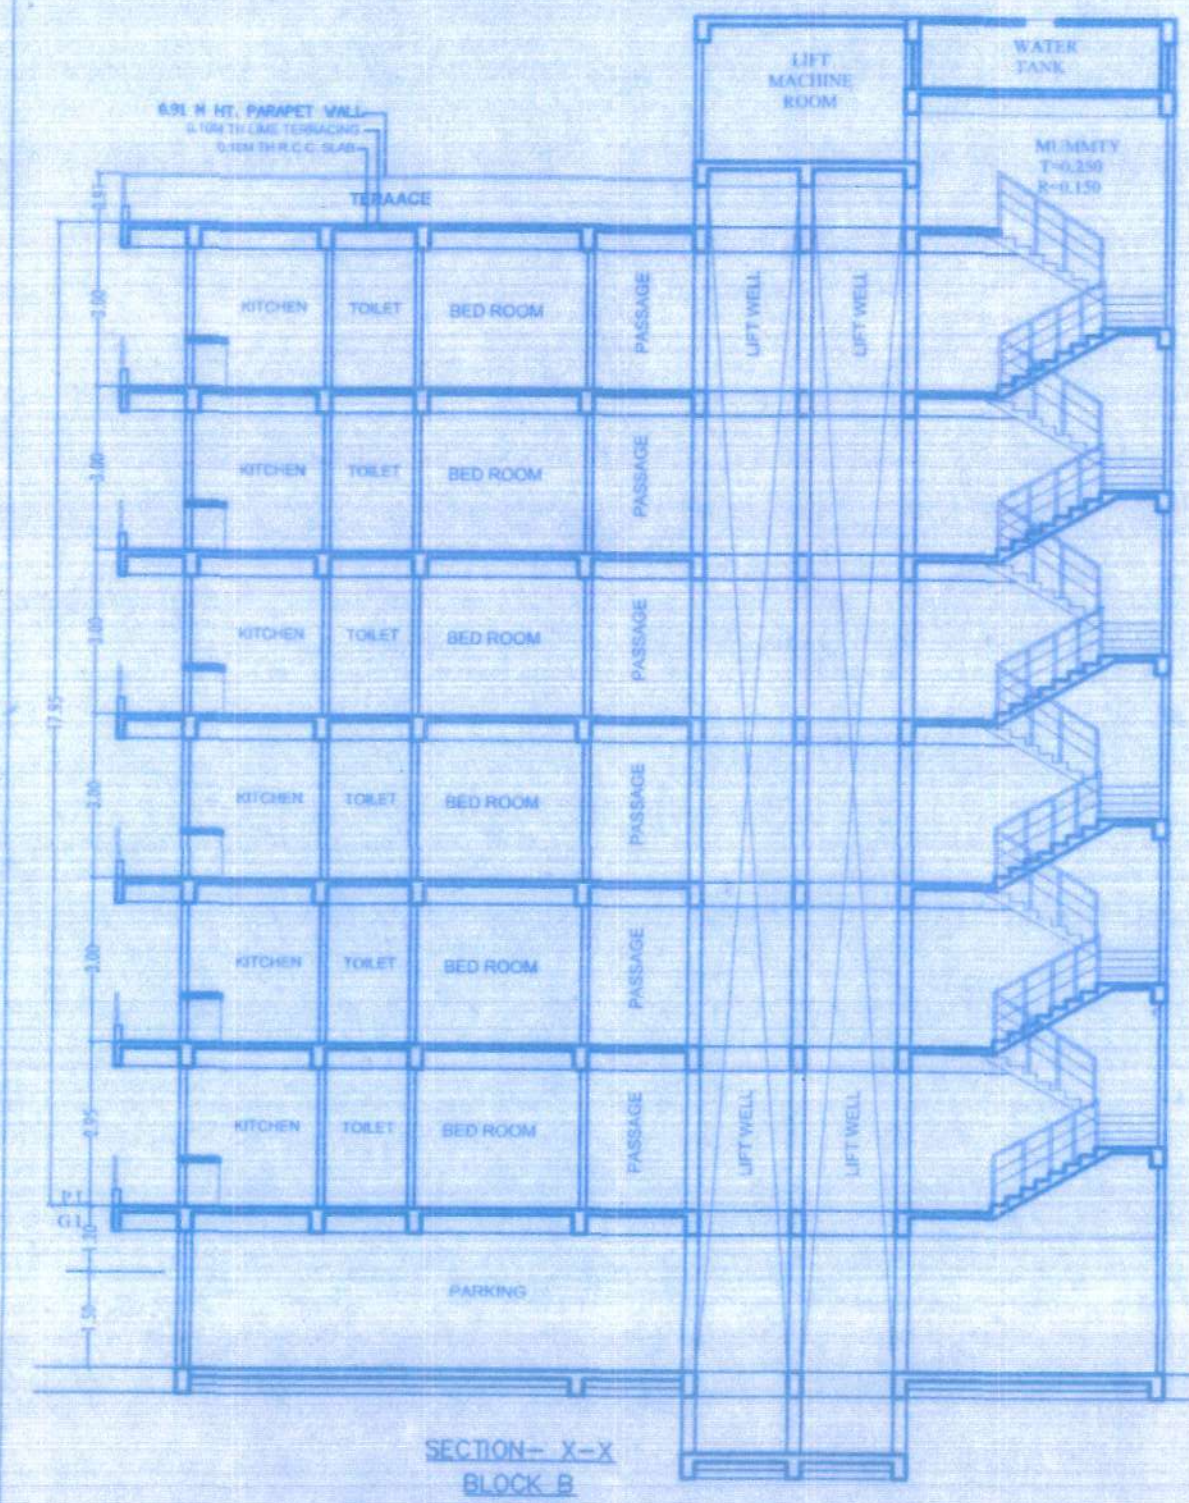

MAIN LAHERIASARAI - DARBHANGA ROAD



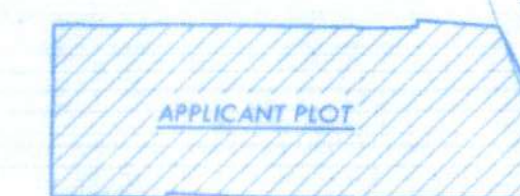


FIRE LEGEND :-

01. HYDRANT OUT LET VALVE WET	02. HOSE REEL	03. SEMAC CONNECTED FOR FIRE BRIGADE CONNECTED TO WET RISER	04. ELECTRICALLY INSULATED METAL STRIP	05. UNDER GROUND TANK OF 100,000 LTRS	06. O.H.W. TANK FOR FIRE FIGHTING	07. INDICATOR PANEL	08. FIRE ALARM CALL POINT	09. AUDIBLE ALARM CALL POINT	10. LOUDSPEAKER OUTLET	11. CO2 FIRE EXTINGUISHER	12. FIRE RESISTANT DOOR	13. AUTOMATIC SMOKE DETECTOR	14. AUTOMATIC SPRINKLER INSTALLATION

SCHEDULE OF DOORS & WINDOWS

S.NO.	TYPE	WIDTH	HEIGHT	DESCRIPTION
01	DO	1.80	2.10	SINGLE DOOR
02	DO	1.80	2.10	SINGLE DOOR
03	DO	1.80	2.10	SINGLE DOOR
04	DO	1.80	2.10	SINGLE DOOR
05	DO	1.80	2.10	SINGLE DOOR
06	DO	1.80	2.10	SINGLE DOOR
07	DO	1.80	2.10	SINGLE DOOR
08	DO	1.80	2.10	SINGLE DOOR
09	DO	1.80	2.10	SINGLE DOOR
10	DO	1.80	2.10	SINGLE DOOR
11	DO	1.80	2.10	SINGLE DOOR
12	DO	1.80	2.10	SINGLE DOOR
13	DO	1.80	2.10	SINGLE DOOR
14	DO	1.80	2.10	SINGLE DOOR

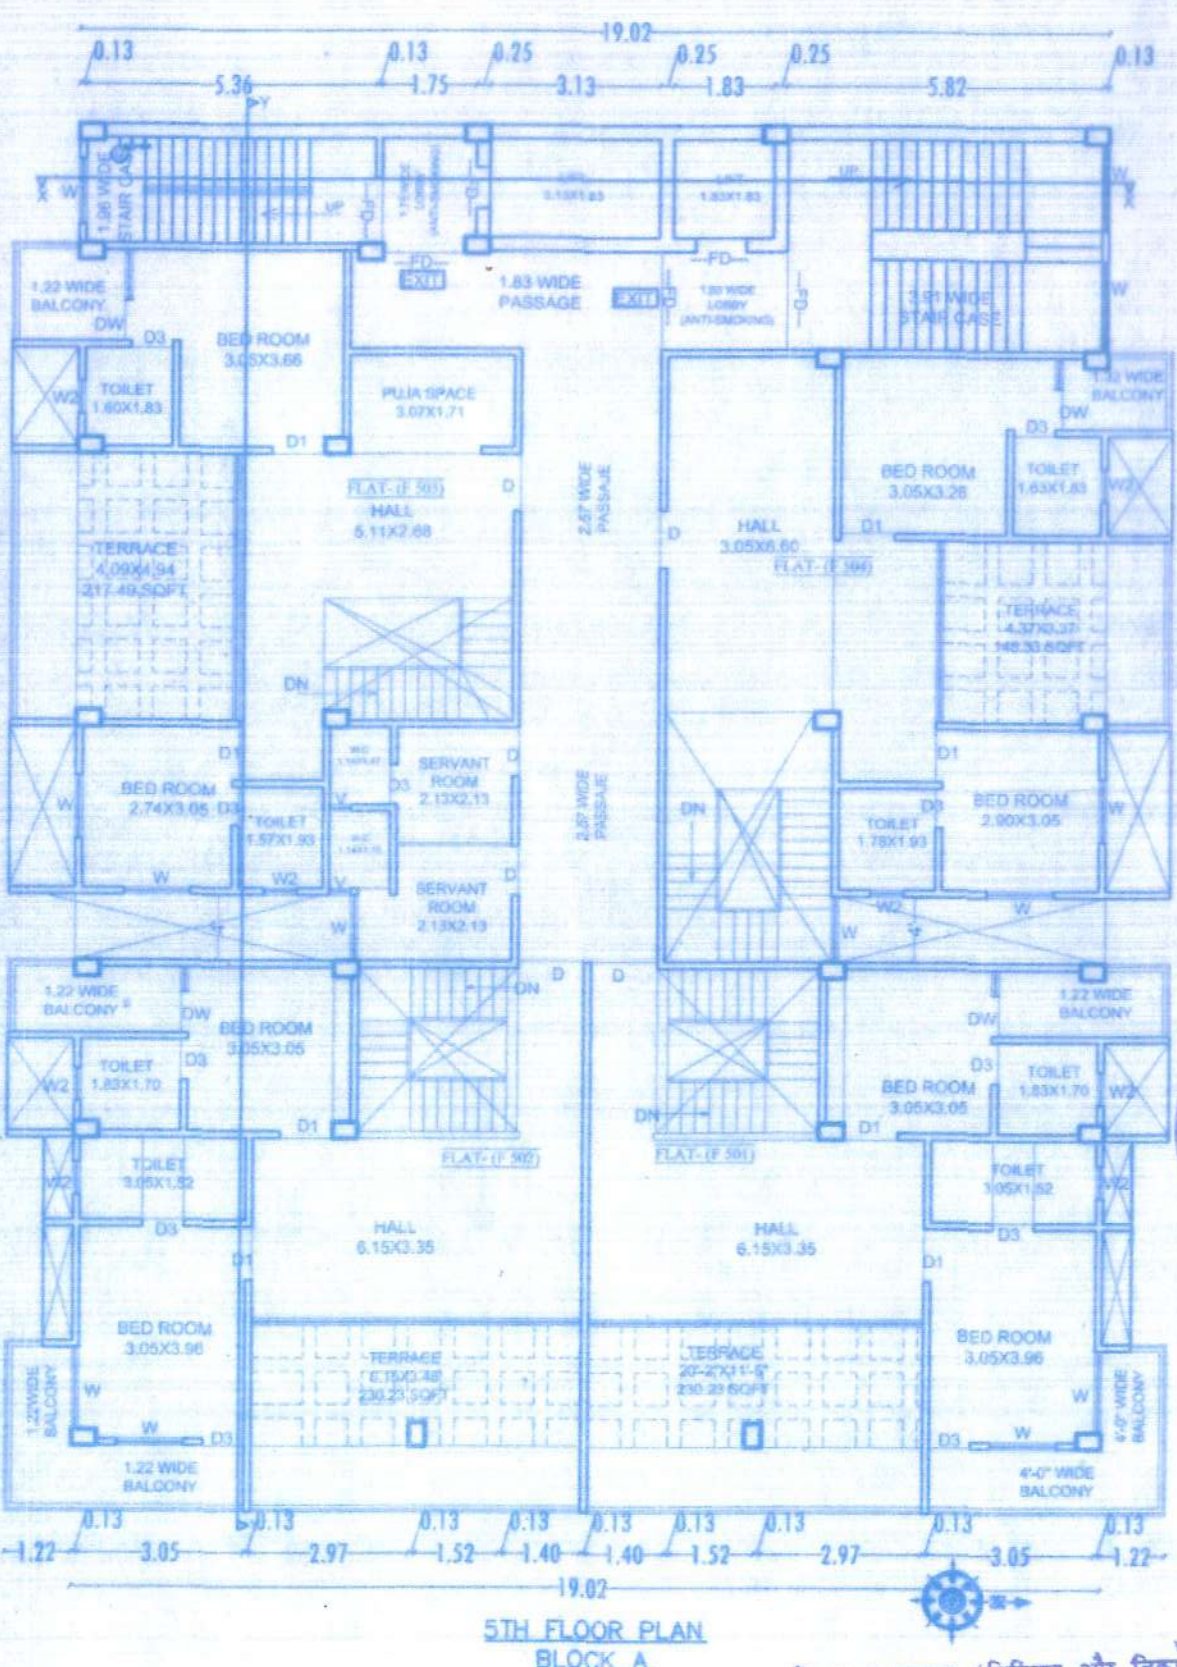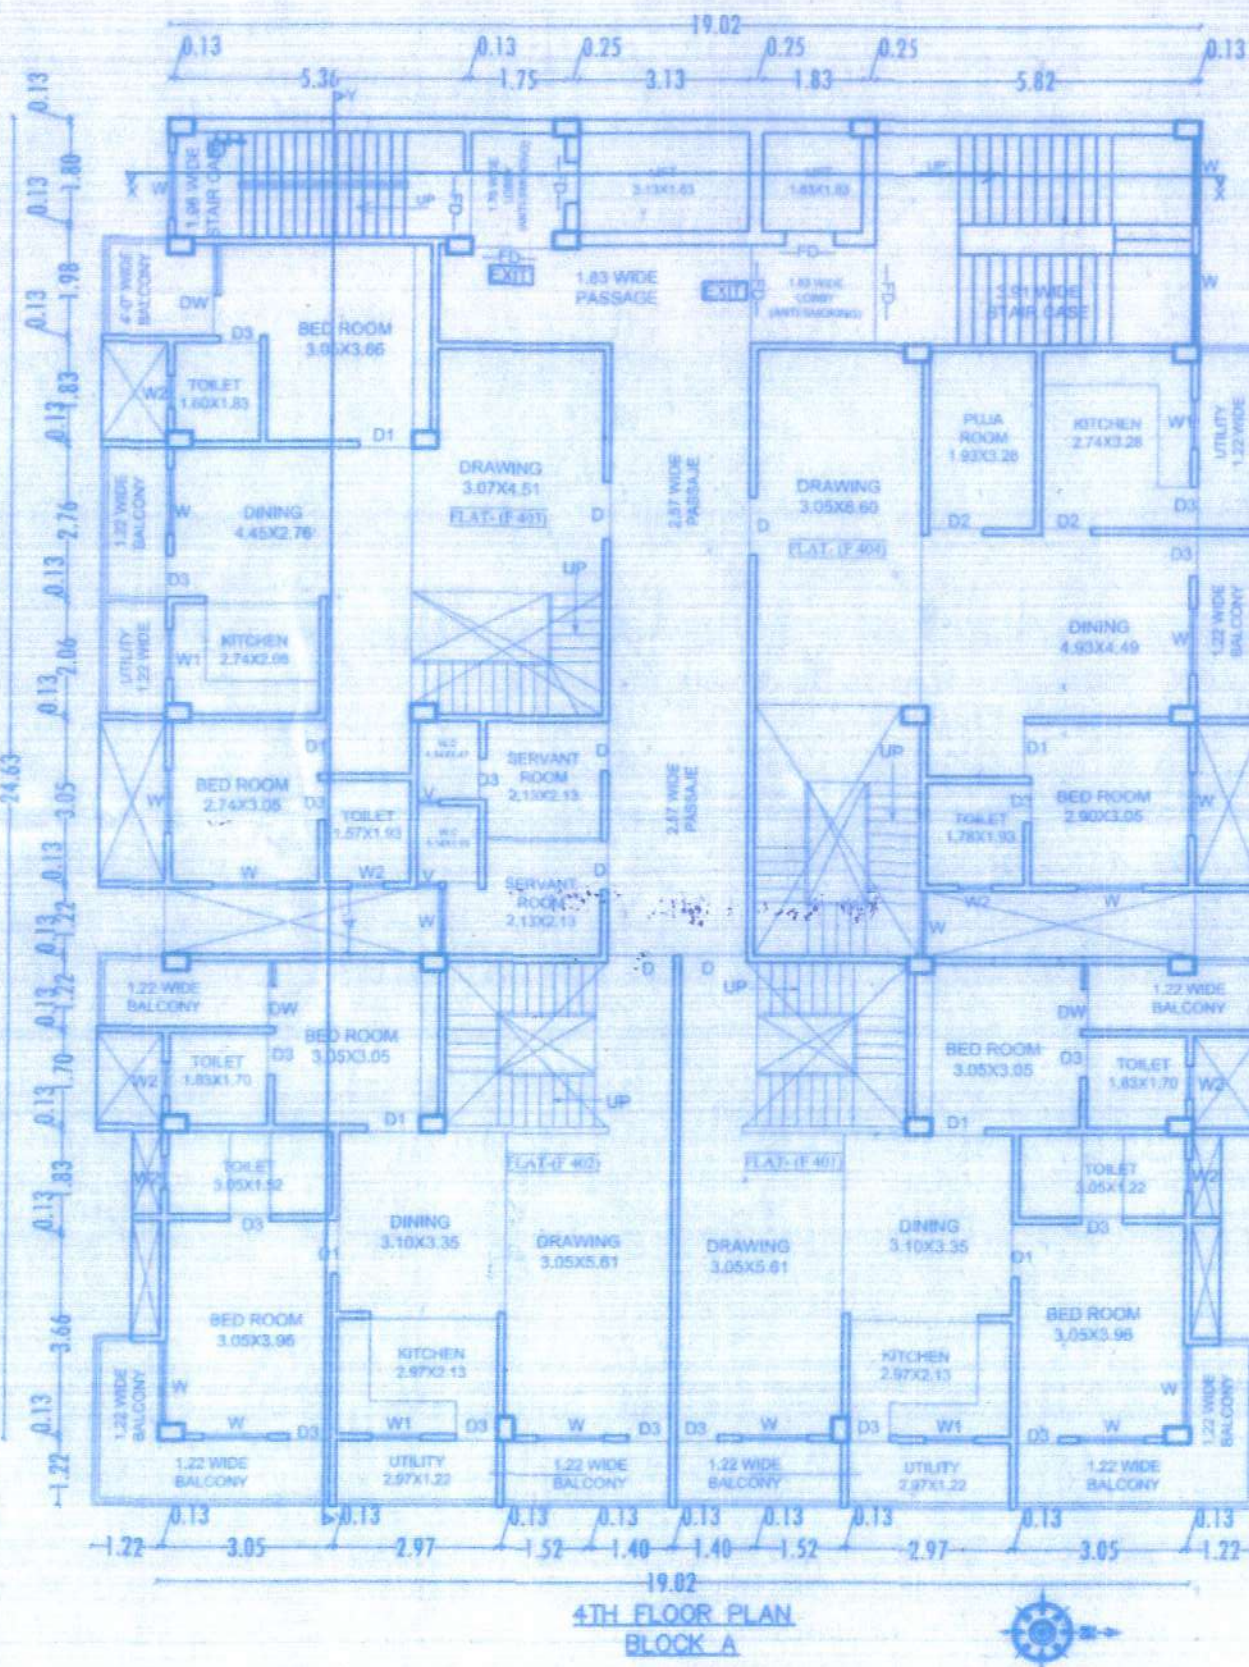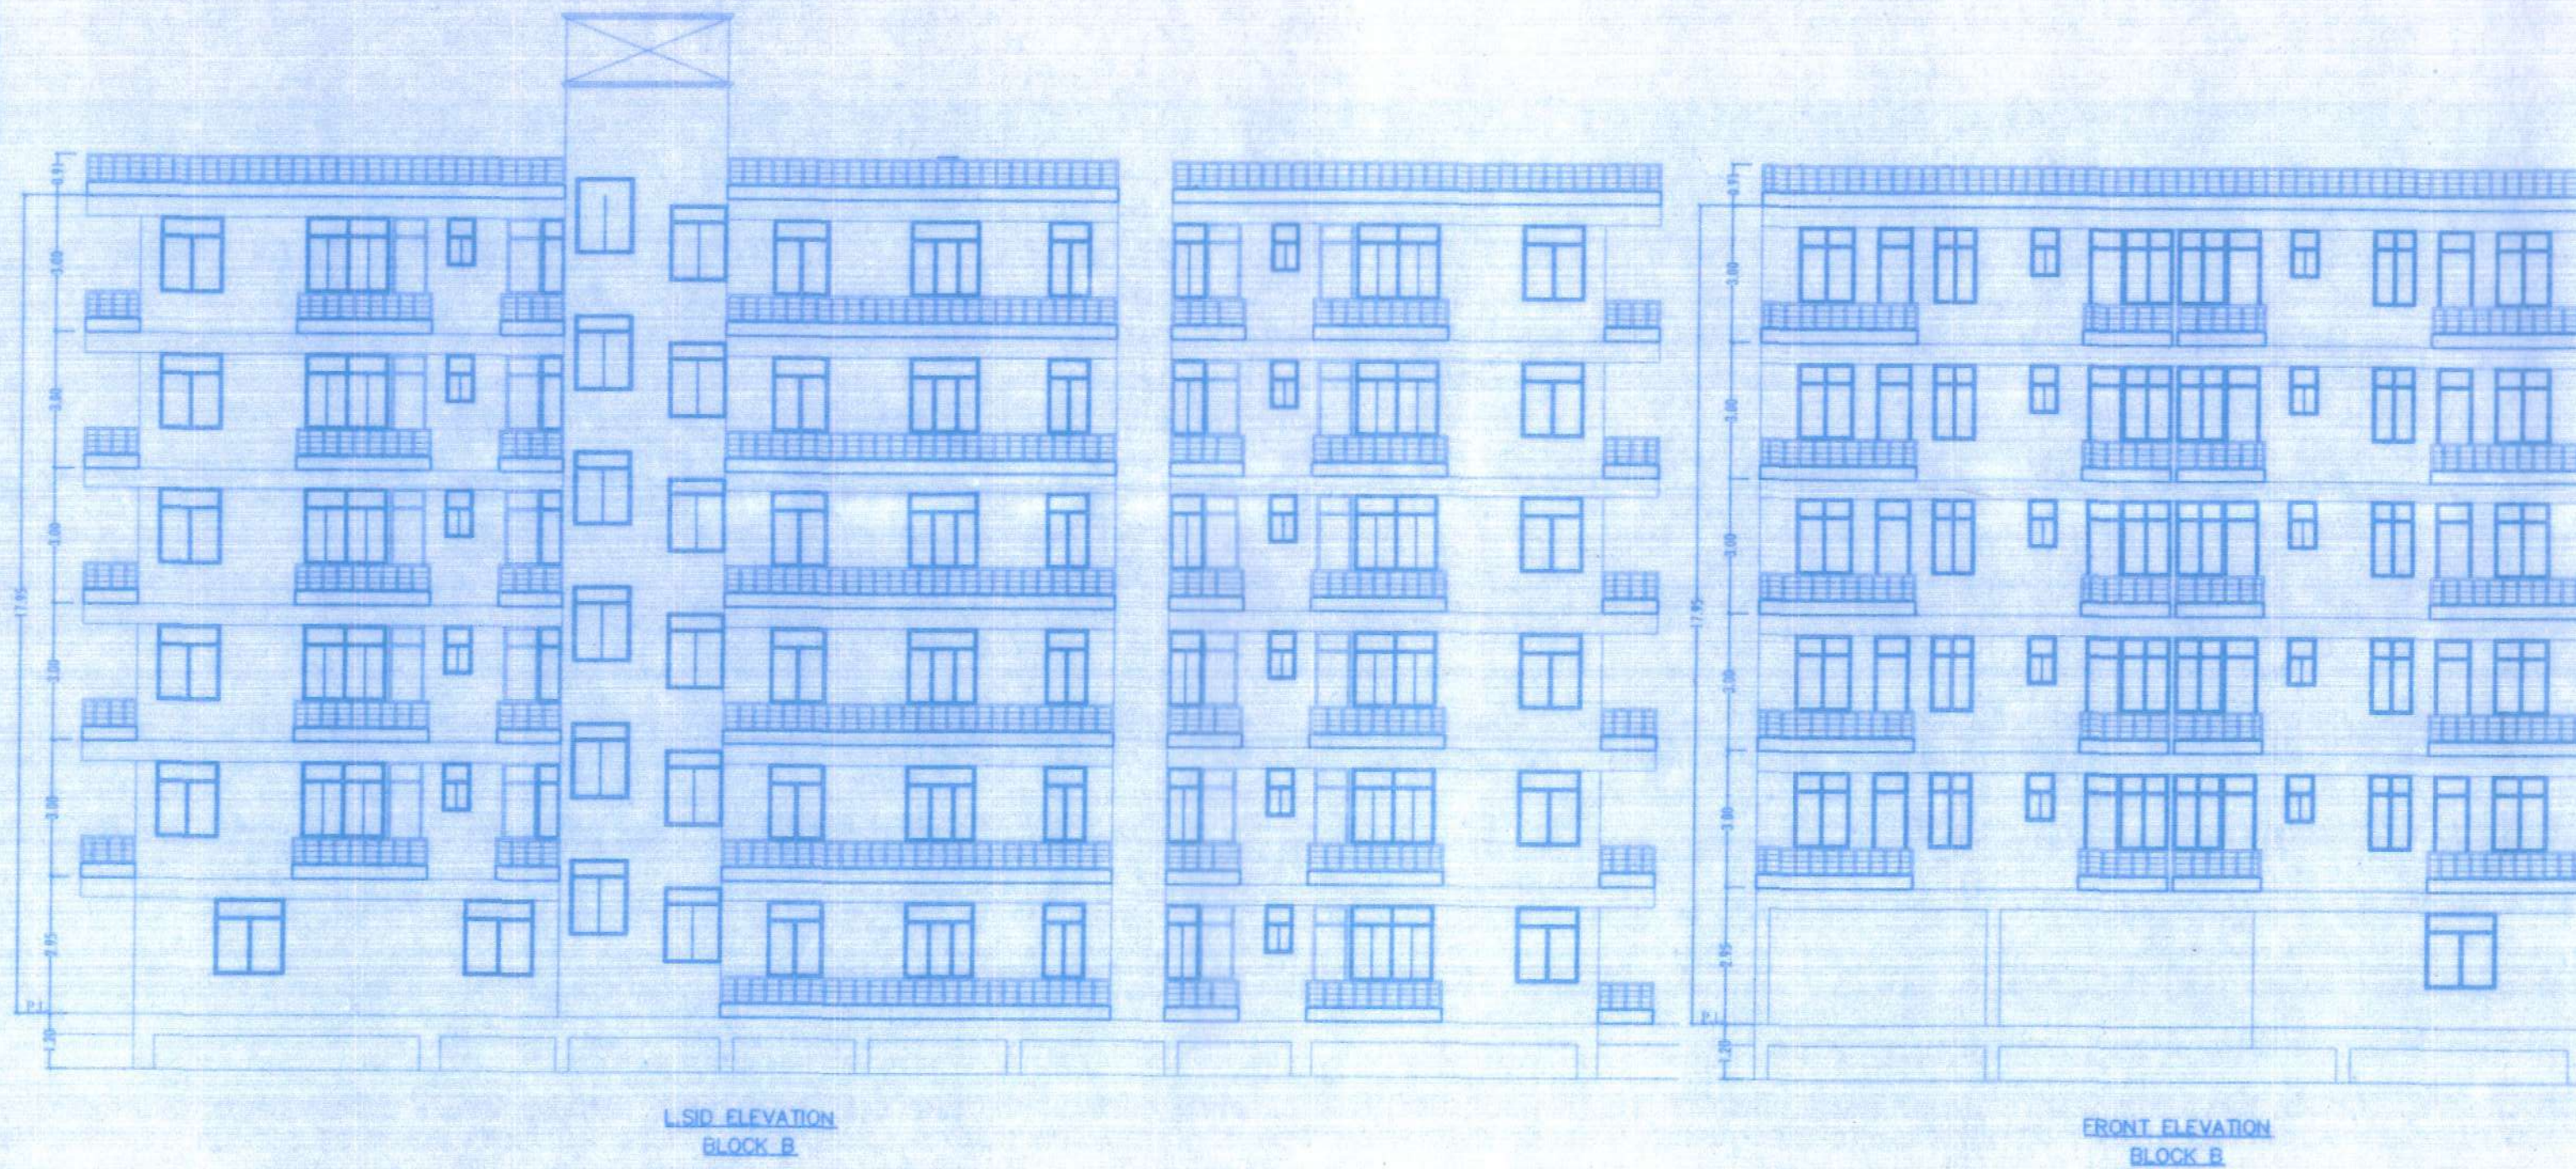

PLOT DETAILS :-
PROPOSED B+G+5 COMMERCIAL CUM RESIDENTIAL & B+G+5 RESIDENTIAL BUILDING OF DEVELOPERS:
NEXGEN INFRA HEIGHTS PVT LTD
MR. RAVIKANT SINGH
S/O - KAMLESHWAR SINGH
C/O - B-3, VINITA VILLA, SIDHARTH NAGAR, JAGDEOPATH, BAILEY ROAD, P.S. RUPASPUR, DISTRICT - PATNA.

LANDOWNERS:-
 1) SMT. PUSHPA SINGH, W/O LATE AMAR NARAYAN SINGH
 2) SRI. GANDHARVA NARAYAN SINGH, S/O LATE AMAR NARAYAN SINGH
 3) KUMAR GAURAV, S/O LATE AMAR NARAYAN SINGH
 4) SMT. ANULIKA SINGH, D/O LATE AMAR NARAYAN SINGH
 5) SMT. RENU SINGH, W/O LATE ARUN NARAYAN SINGH
 ALL R/O KHARARI HOUSE, KHAJA SARAI, LAHERIASARAI, DARBHANGA - 846001

MAUZA - KHAJA SARAI, THANA - LAHERIASARAI, THANA NO- 238, KHATA NO-46, PLOT NO - 207, DIST - DARBHANGA

SHEET NO.	SCALE	NORTH
DMD-03-03	1:100 1:200	

For Nexgen Infra Heights Pvt. Ltd.
Ravi Kant Singh
Director
EMP. NO. CA/2012/56055
UDHD, BIHAR


Er. Manoj Kumar
STRUCTURAL ENGINEER
BRUDH/SE/23-0116
UDHD, BIHAR

Ishtiaq
Junior Engineer
UDHD, BIHAR


Nandhan
6/12/2021
Assistant Engineer
Darbhang Municipal Corporation
DARBHANGA

बिहार प-सम्पदा (विनियम और विकास) अधिनियम 2017 को शर्तों के अधीन राज्य में रजिस्टर प-सम्पदा प्राधिकरण से इस परिवर्तन का निवेदन अंतिम होगा।


P.C.C ROAD

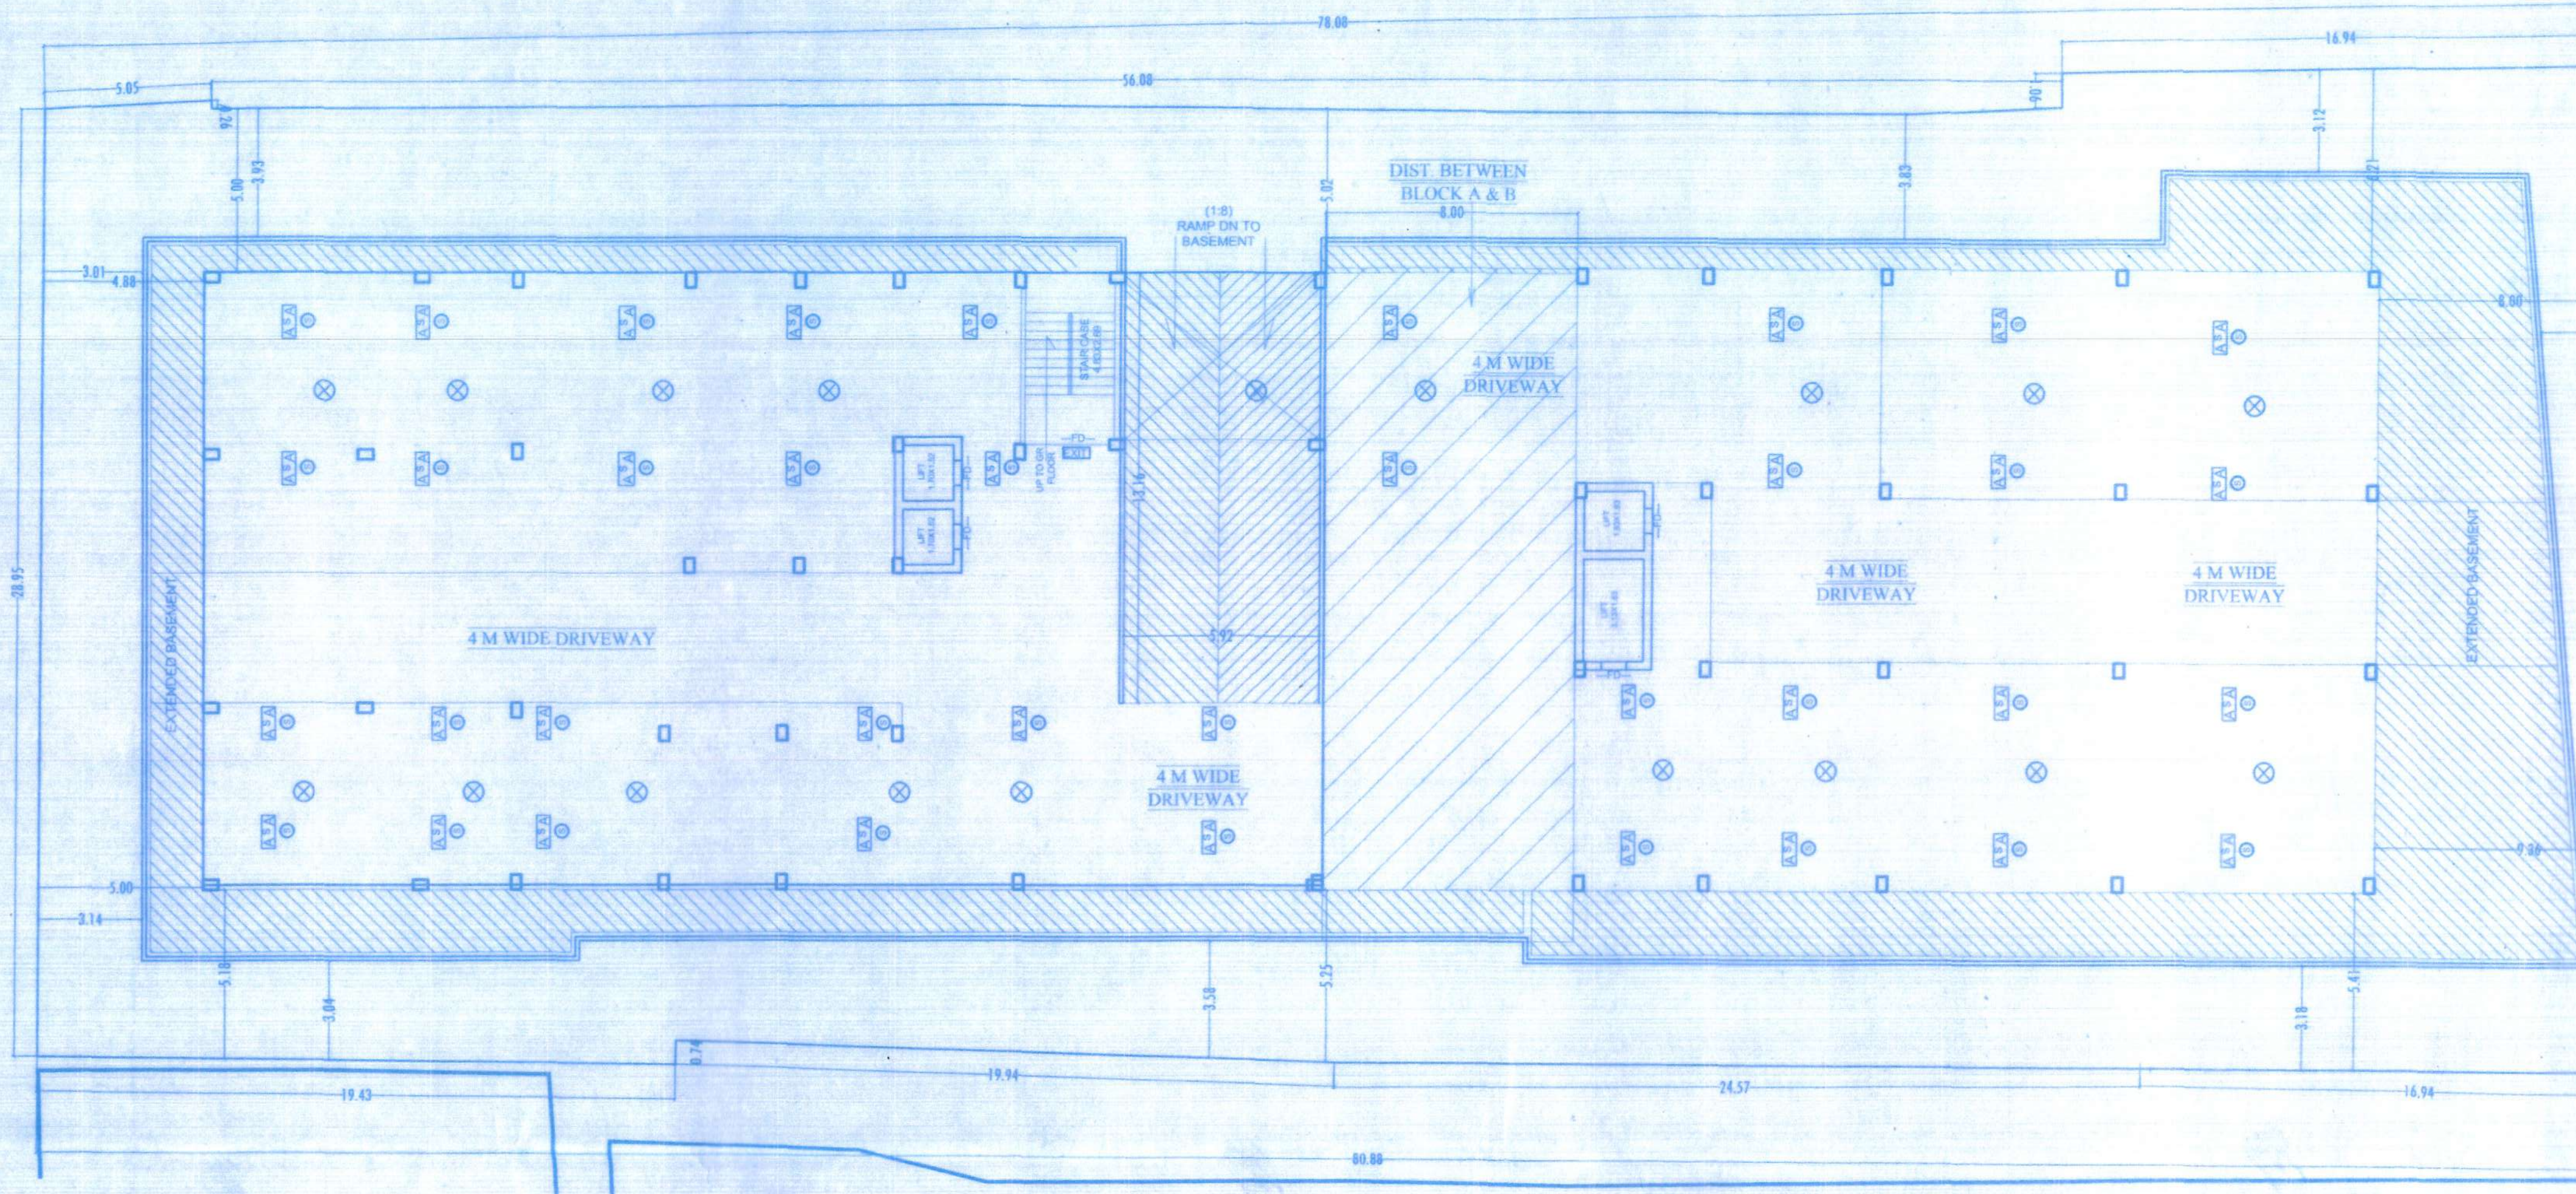


BASEMENT FLOOR PLAN
BLOCK A+B

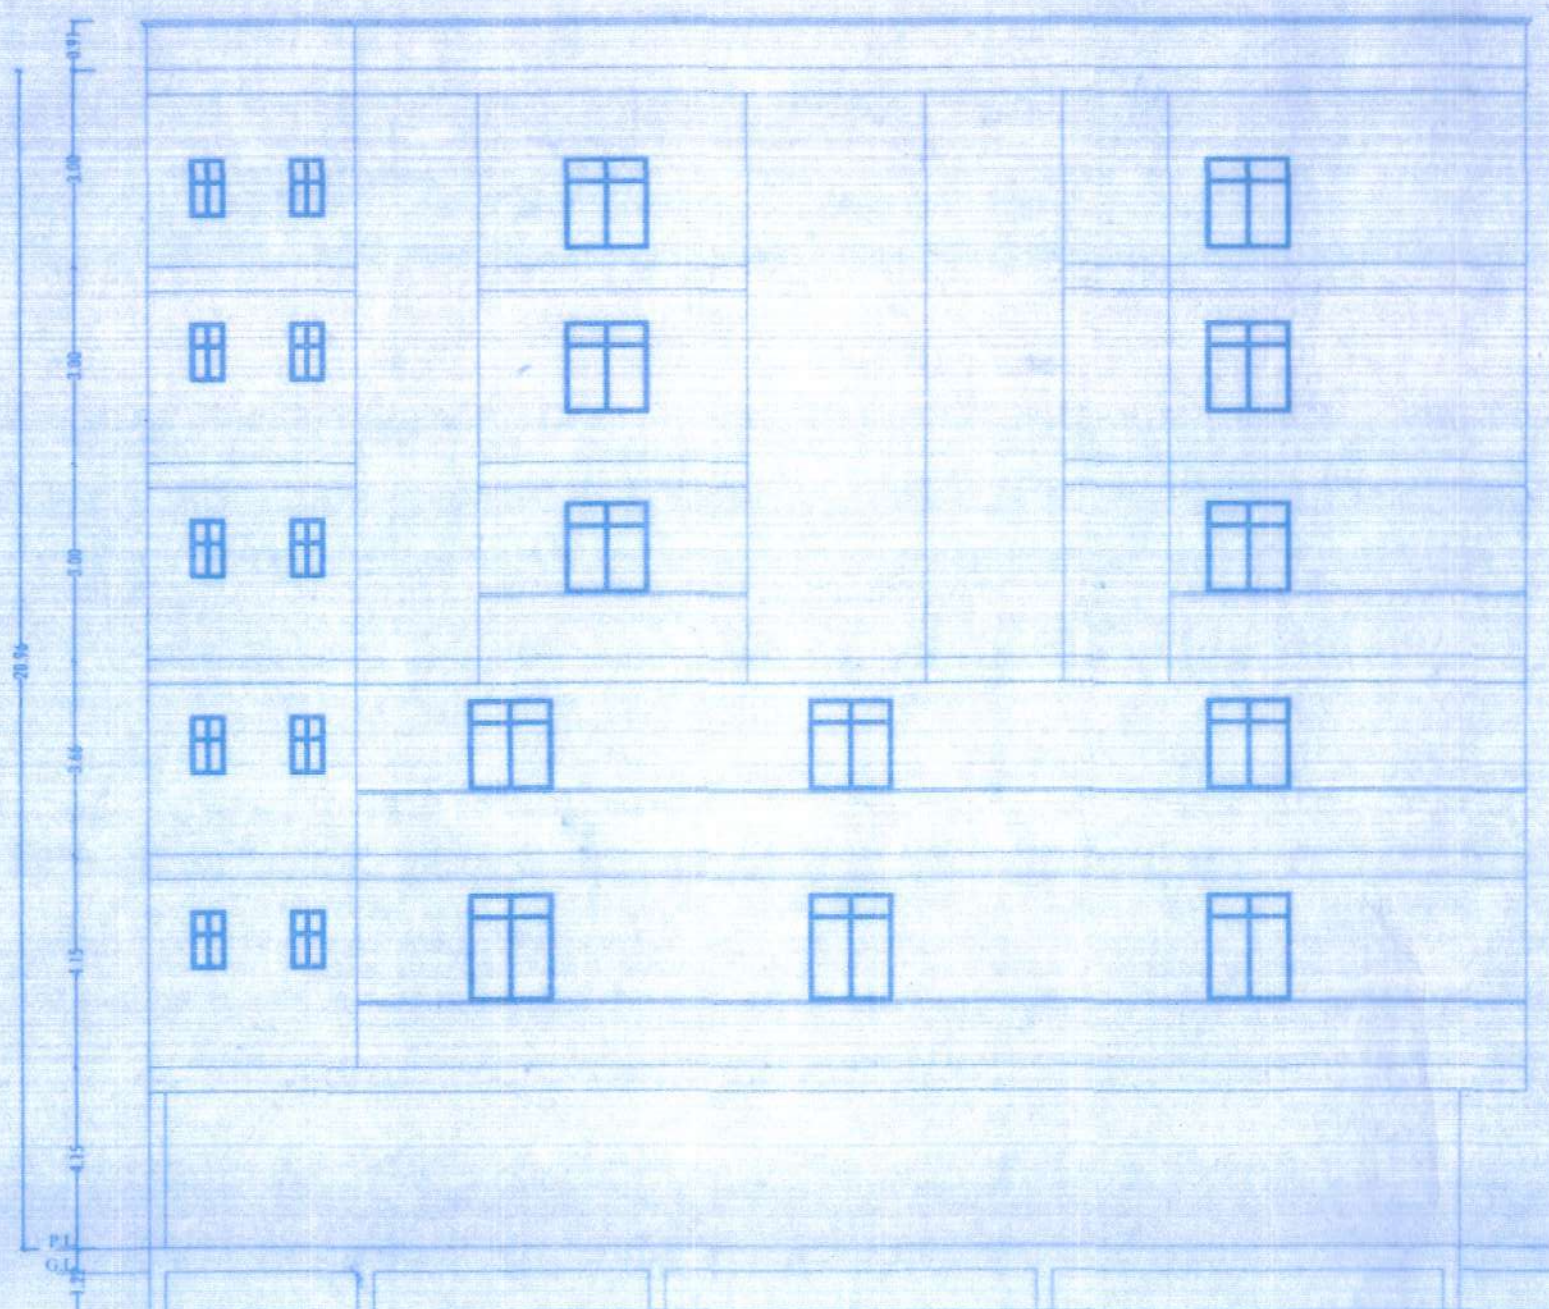


Left ELEVATION
BLOCK A

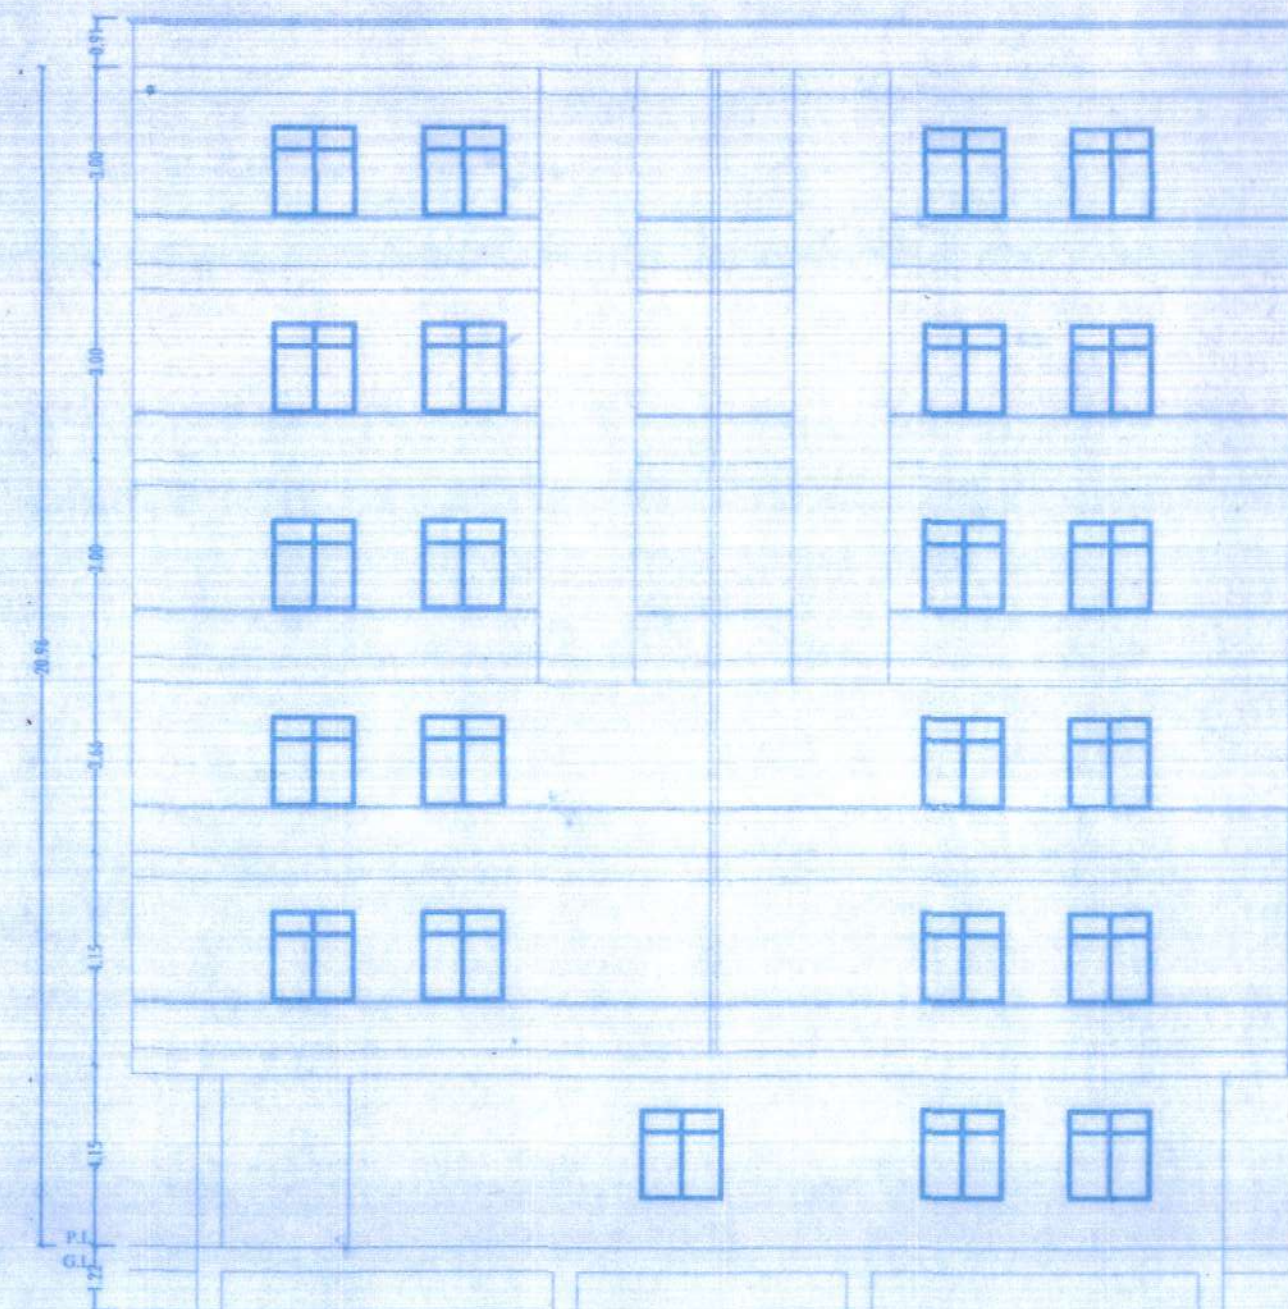

FRONT ELEVATION
BLOCK A



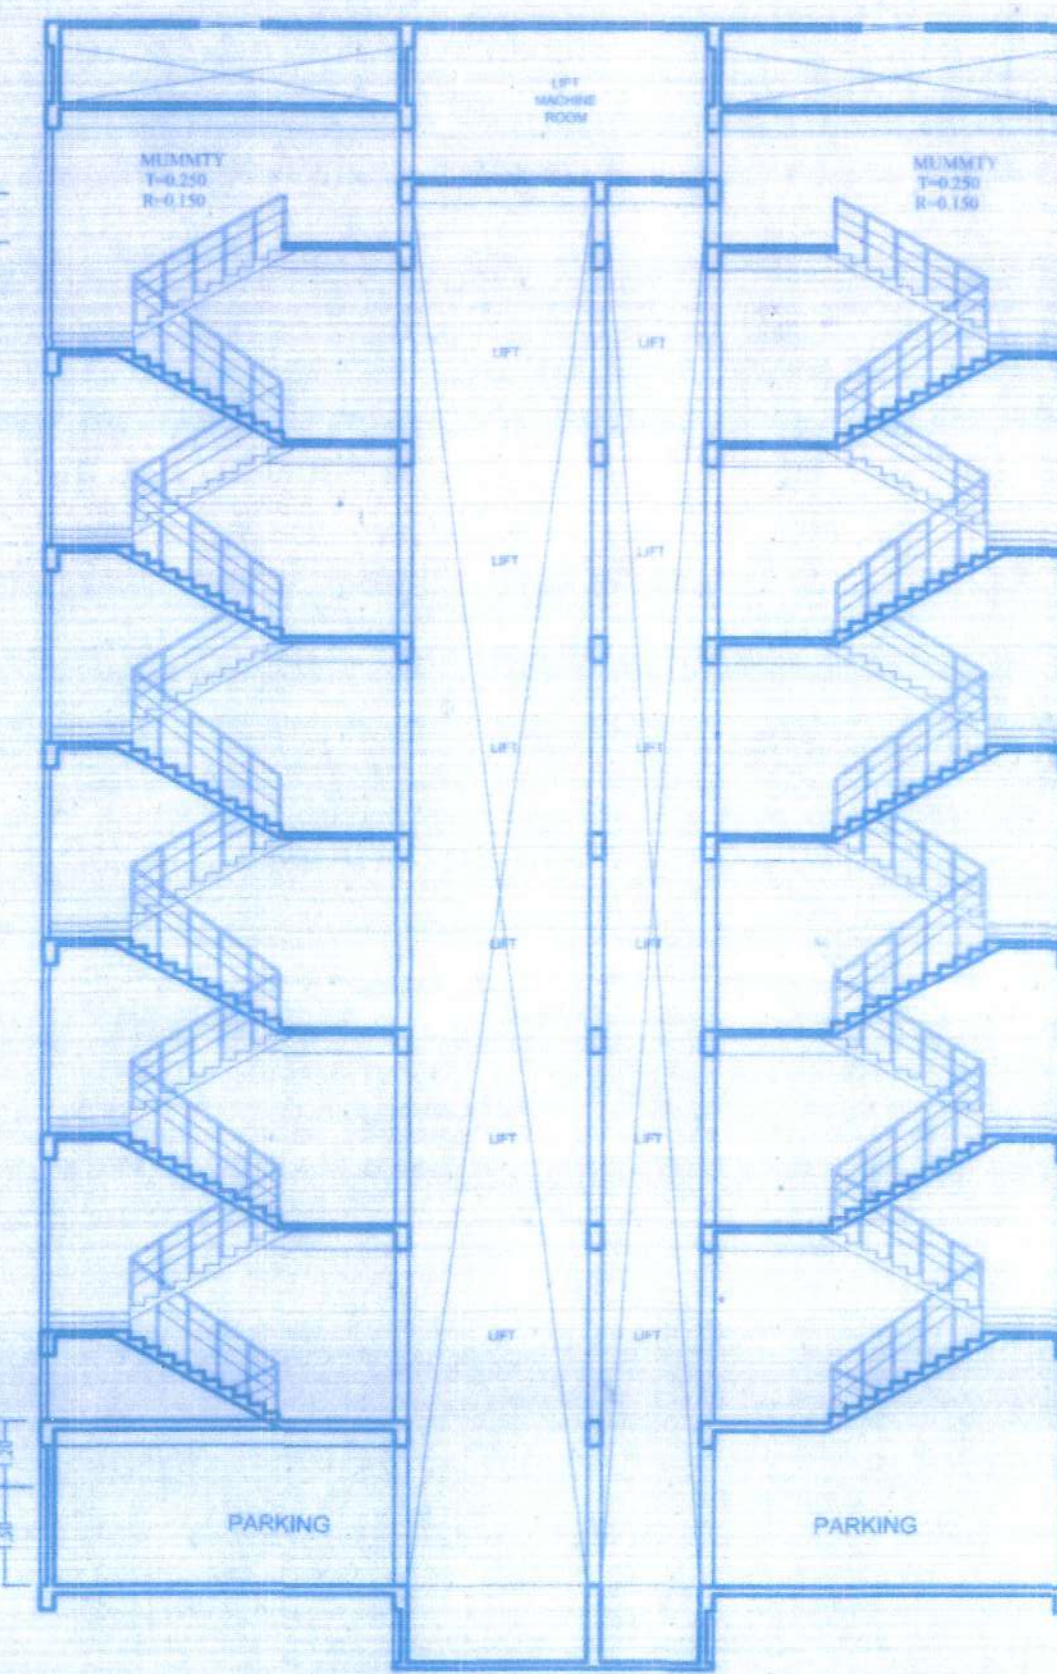


SECTION - X-X
BLOCK A

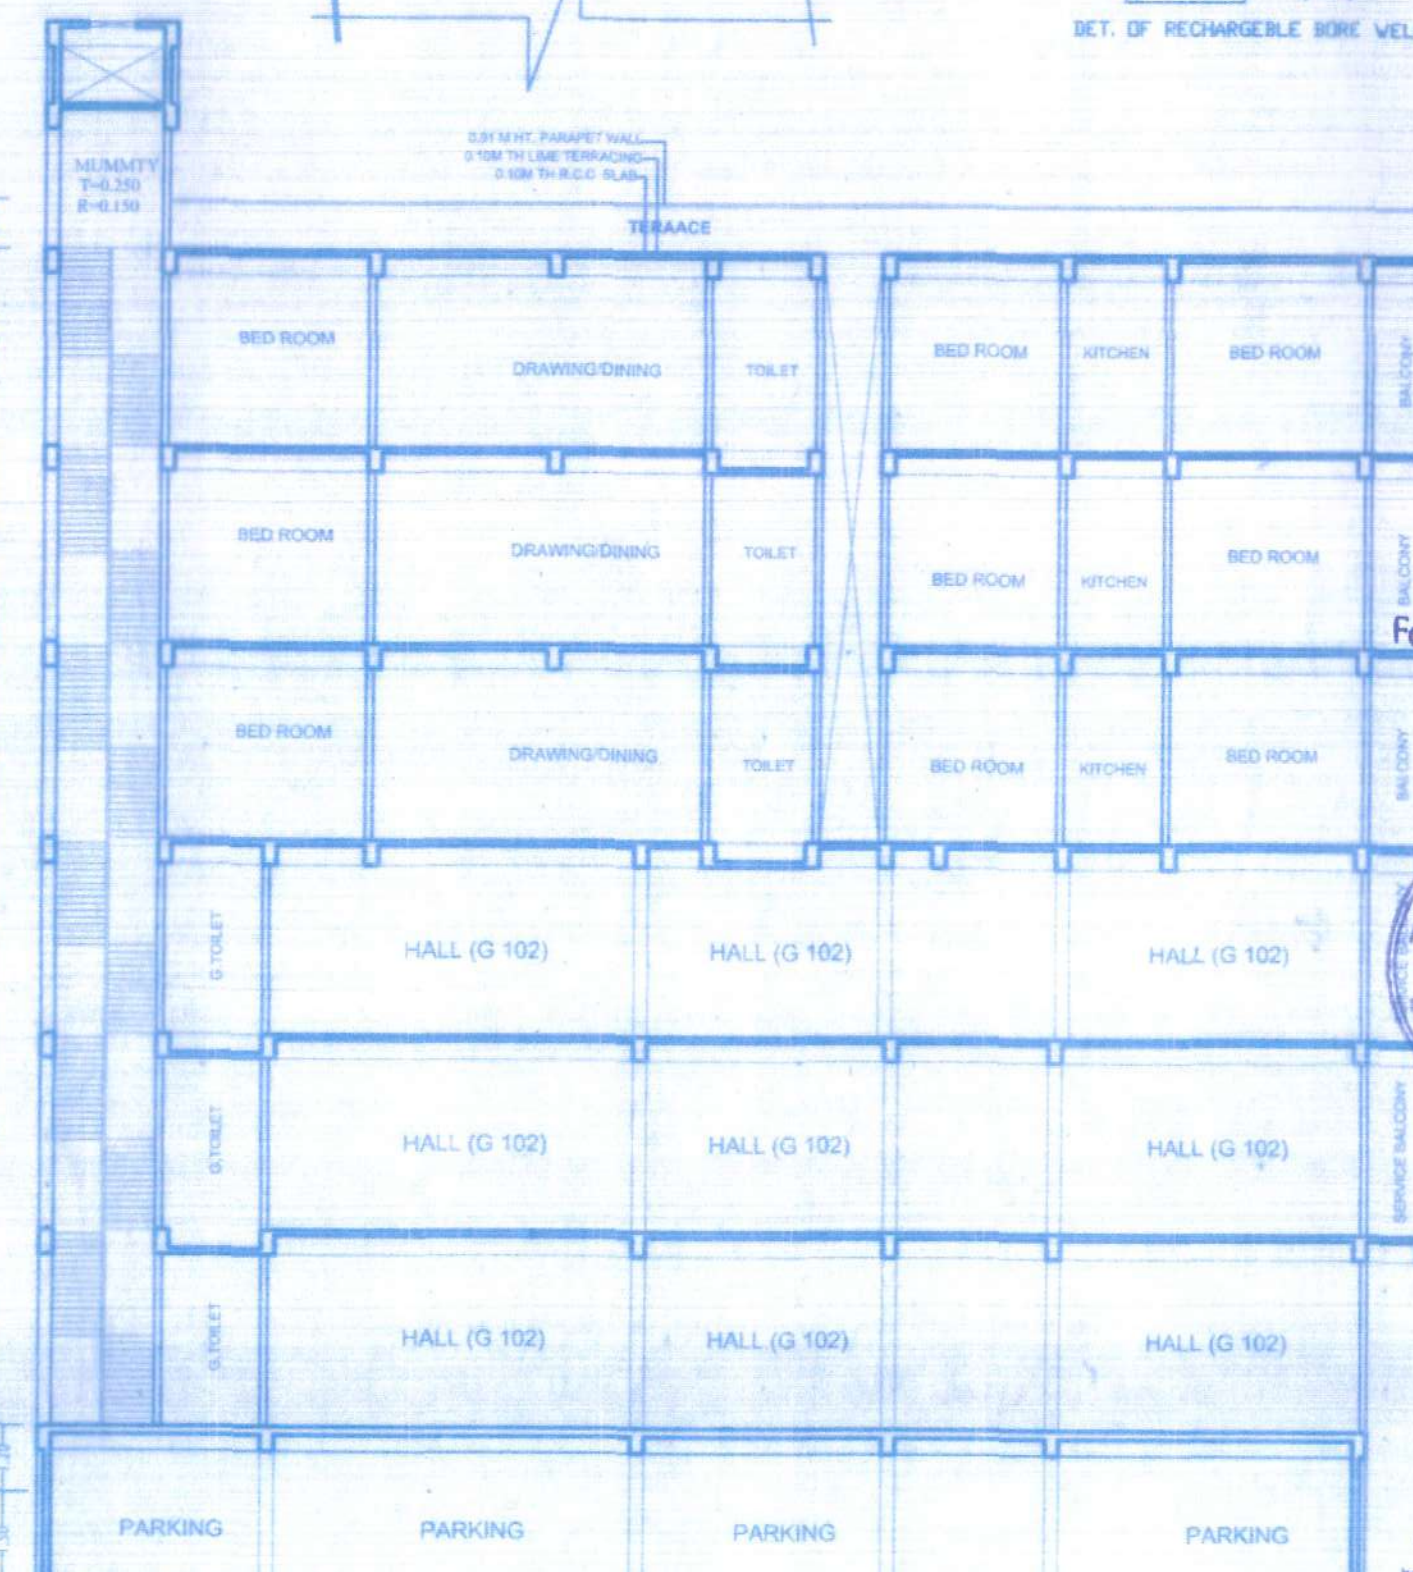

SECTION - Y-Y
BLOCK A

- FIRE LEGEND :-**
- 01. HYDRANT OUT LET VALVE WET
 - 02. HOSE REEL
 - 03. SEMAC CONNECTED FOR FIRE
 - 04. BRIGADE CONNECTED TO WET RISER
 - 05. ELECTRICALLY INSULATED METAL STRIP
 - 06. UNDER GROUND TANK OF 100,000 LTRS
 - 07. O.H.W TANK FOR FIRE FIGHTING
 - 08. INDICATOR PANEL
 - 09. FIRE ALARM CALL POINT
 - 10. AUDIBLE ALARM CALL POINT
 - 11. LOUDSPEAKER OUTLET
 - 12. CO2 FIRE EXTINGUISHER
 - 13. FIRE RESISTANT DOOR
 - 14. AUTOMATIC SMOKE DETECTOR
 - 15. AUTOMATIC SPRINKLER INSTALLATION

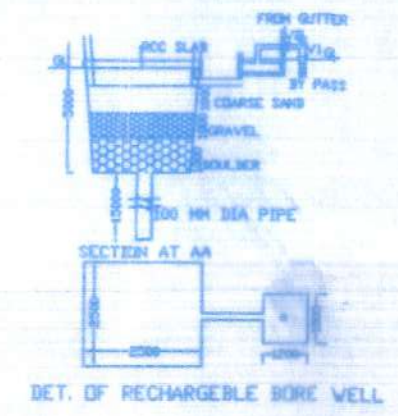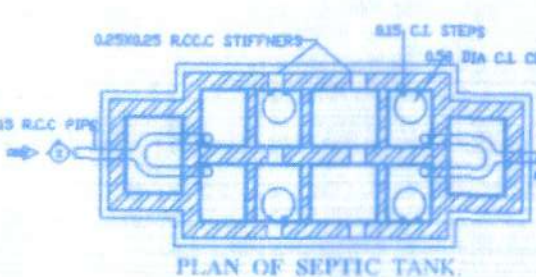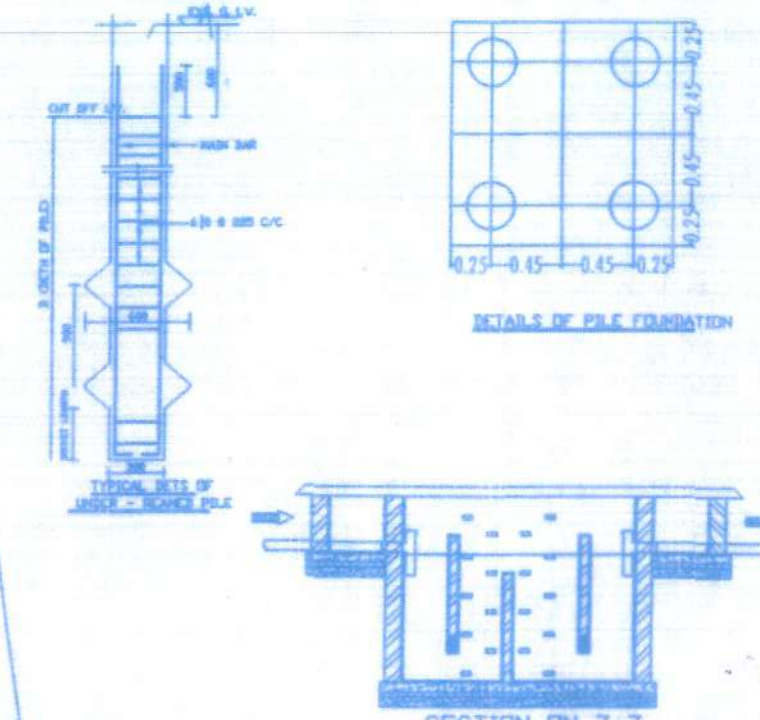

S.NO	TYPE	WIDTH	CLL	HEIGHT	DESCRIPTION
01	B	1.67	0.0	0.15	SINGLE LEAF DOOR
02	B	0.94	0.0	0.15	SINGLE LEAF DOOR
03	B	0.94	0.0	0.15	SINGLE LEAF DOOR
04	B	0.76	0.0	0.15	SINGLE LEAF DOOR
05	B	1.49	0.76	1.78	FULLY GLAZED VRL
06	V	1.37	0.76	1.78	FULLY GLAZED VRL
07	V	1.28	0.76	1.78	FULLY GLAZED VRL
08	V	0.94	1.49	1.49	FULLY GLAZED VRL
09	V	0.94	1.49	1.49	FULLY GLAZED VRL
10	V	1.67	0.76	1.78	FULLY GLAZED VRL
11	S	2.44	0.00	0.54	SLIDING DOOR

PLOT DETAILS :-
PROPOSED B+G+5 COMMERCIAL CUM
RESIDENTIAL & B+G+5 RESIDENTIAL
BUILDING OF DEVELOPERS:
NEXGEN INFRA HEIGHTS PVT LTD
MR. RAVIKANT SINGH
S/O - B.S. VINITA VILLA, SIDHARTH NAGAR,
JAGDEOPATH, BAILEY ROAD,
P.S. RUPASPUR, DISTRICT - PATNA.

LANDOWNERS:-
1) SMT. PUSHPA SINGH, W/O LATE AMAR NARAYAN SINGH
2) SRI. GANDHARVA NARAYAN SINGH,
S/O LATE AMAR NARAYAN SINGH
3) KUMAR GAURAV, S/O LATE AMAR NARAYAN SINGH
4) SMT. ANULIKA SINGH, D/O LATE AMAR NARAYAN SINGH
5) SMT. RENU SINGH, W/O LATE ARUN NARAYAN SINGH
ALL R/O KHARARI HOUSE, KHARARI SARAI, LAHARIASARAI,
DARBHANGA - 848001

MAUZA - KHARARI SARAI, THANA - LAHARIASARAI,
THANA NO- 238, KHATA NO-46, PLOT NO - 207,
DIST - DARBHANGA

SHEET NO.	SCALE	NORTH
DMC-03/01	1 : 100 1 : 200	

For Nexgen Infra Heights Pvt. Ltd.
Ravi Kant Singh
DIRECTOR

SIGNATURE OF OWNER

SIGNATURE OF ARCHITECT

Er. Manoj Kumar
STRUCTURAL ENGINEER
BTR/UDHD/SE/23-0116
UDHD, GOVERNMENT OF BIHAR

Er. Manoj Kumar
STRUCTURAL ENGINEER
BTR/UDHD/SE/23-0116
UDHD, GOVERNMENT OF BIHAR

