



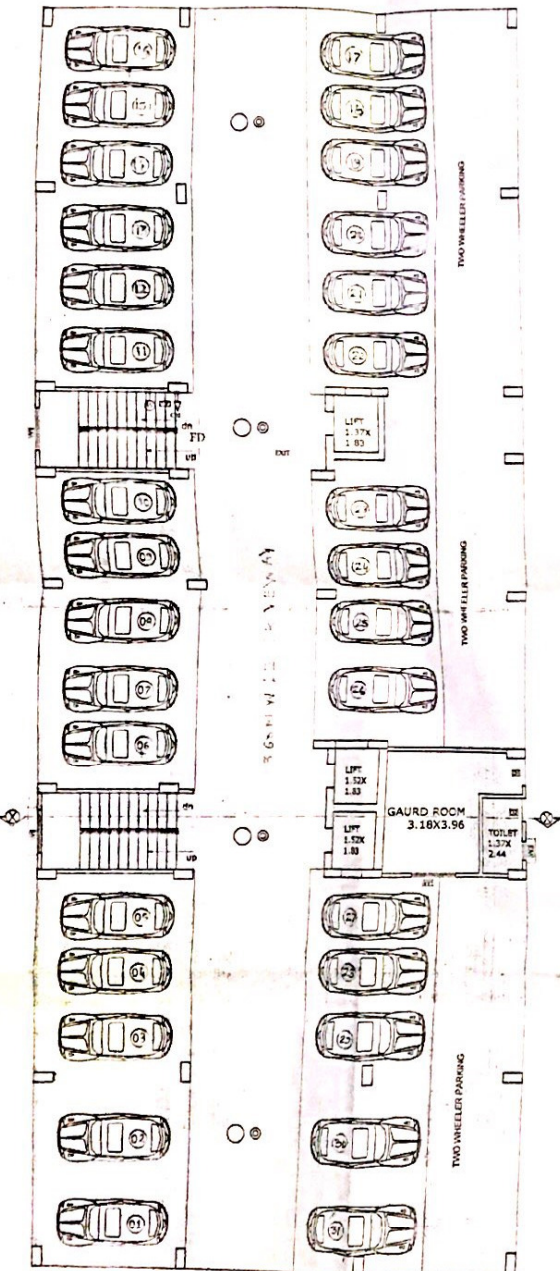


GROUND & PARKING FLOOR PLAN (BLOCK -A&B)

Sample output to test PDF Combine only

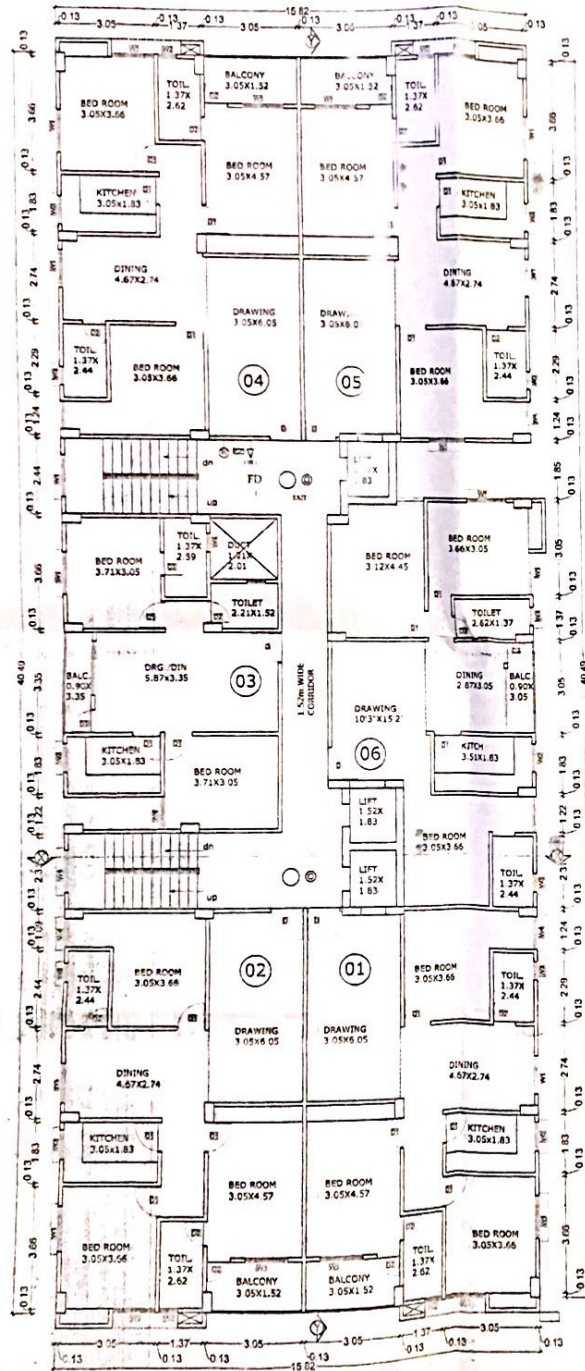

1ST FLOOR PLAN (BLOCK -A&B)

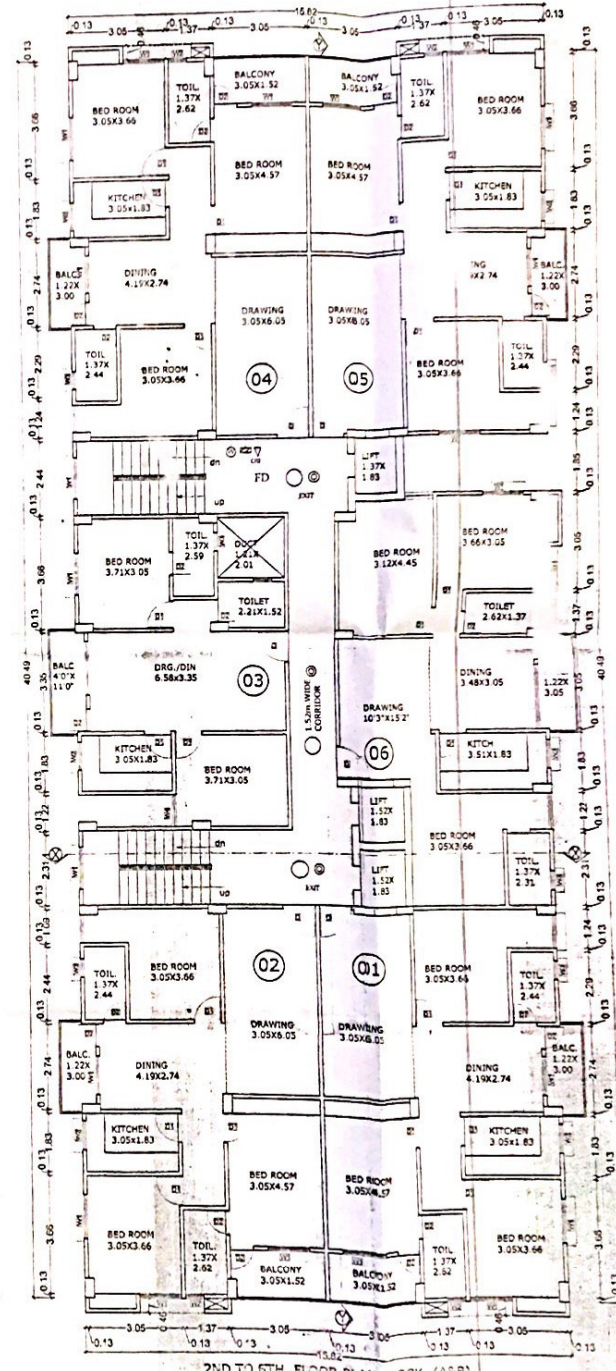

2ND TO 6TH FLOOR PLAN (BLOCK -A&B)

SL.NO.	TYPE	WIDTH	SILL	HEIGHT
1.	D	1.07	0.00	2.13
2.	D1	0.91	0.00	2.13
3.	D2	0.76	0.00	2.13
4.	DW	0.76X0.64	2.19X0.76	2.59X1.83
5.	W	1.52	0.76	1.83
6.	W1	1.22	0.76	1.83
7.	W2	0.92	1.07	1.52
8.	W3	0.61	1.68	0.91
9.	W4	0.97	0.76	1.83

PLOT DETAILS.

PROPOSED RESIDENTIAL BUILDING
FOR ASHIRWAD ENGICON PVT. LTD.
THROUGH ITS DIRECTOR
SMT. MAMTA SINHA
W/O AJAY KUMAR SINGH
AT MAUZA-SHEIKHPURA
MOSUME CHAKASHO
THANA - RAMKRISHNA NAGAR
THANA NO.-111
PLOT NO.-7
KHATA NO.-149
TAUZI -2/176C LAKHRAJ
DIST. - PATNA.

NORTH	SCALE	DRG. NO.
	1:100/1:200	C-2/176C

Ashirwad Engicon Pvt. Ltd.
Director




SIGN. OF OWNER

Ar. PAWAN KUMAR
COA Regd. No.-CA/2008/43278
Empowerment No. 11/2011/12/2011

SIGN. OF ARCHITECT

Plan Number: 1599

मुखिया
श्रीमती पद्मावती कर्कणी कर्कणी
पञ्च-समय-समय (कर्म)
पटना-16

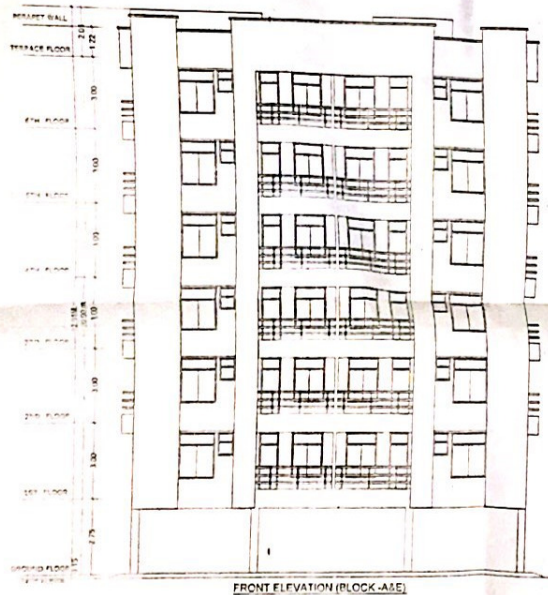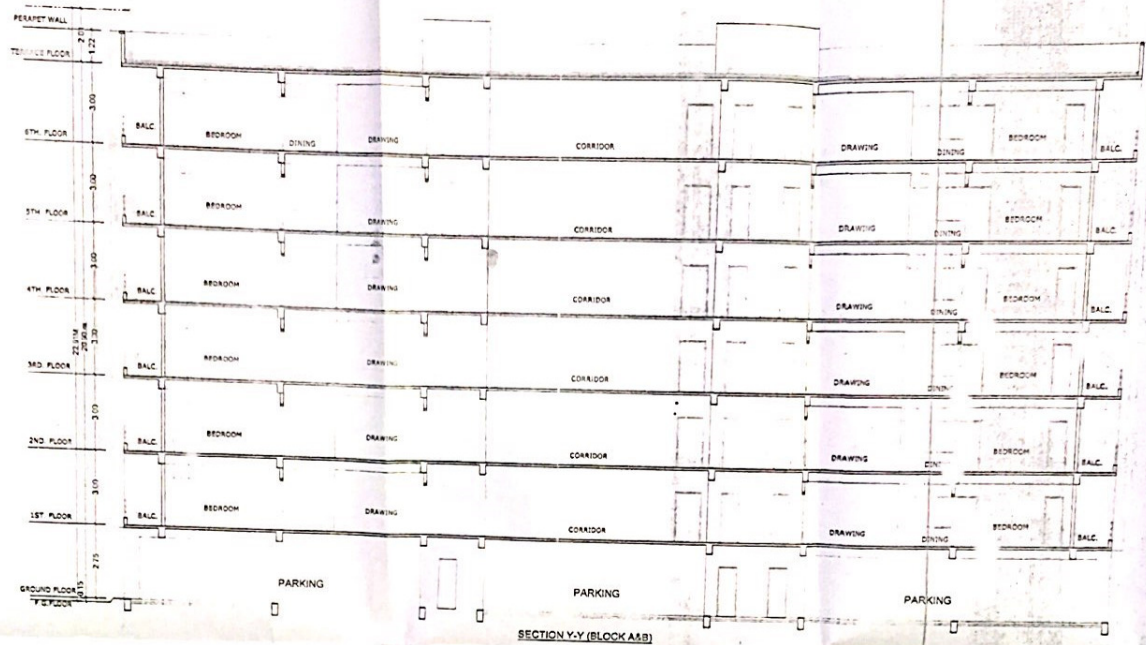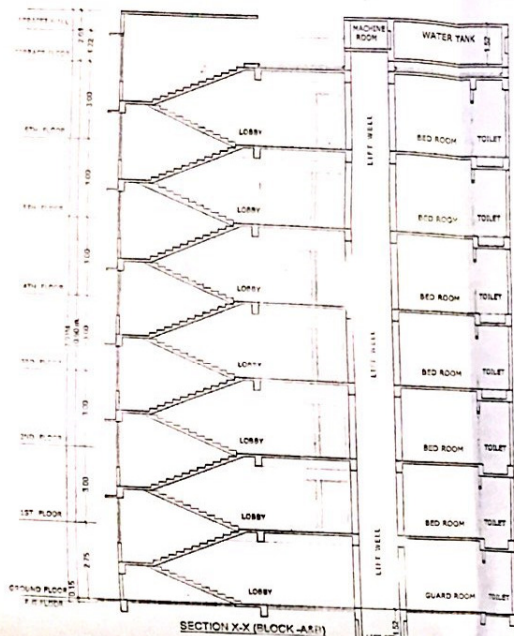

SPECIFICATION	
1	R.C.C UNDER REINFORCED PILE FOUNDATION AS PER DETAIL GIVEN IN THIS DRAWING.
2	1ST CLASS BRICK WORK IN CONCRETE MORTAR IN ALL STRUCTURE.
3	HEIGHT OF PLASTER FLOOR AREA & ROOM IN SECTION.
4	600 LPA FLOORING ON 130 MM DRY BEDDED KIDNEY OVER PLAT BRICK SELLING OVER LOCAL SAND FILLING.
5	600 TH D.P.C ON P.L.A. & ROOF TOP FLOORING.
6	100 MM LIME CONCRETE OVER 80 MM R.C.C SLAB.
7	600 TH R.C.C BAND AT DOORS & WINDOWS OPENING.
8	600 CONCRETE PLASTER ON BOTH SIDES OF WALL.
9	WHITE & COLOUR WASH AS PER CLAUSE.

LEGEND FOR FIRE FIGHTING.	
1) FIRE RESISTANT CHECK DOOR	FD
2) FIRE HYDRANT	PH
3) HOSE REEL	HR
4) UNDER GROUND WATER STATIC TANK WITH AUTOMATIC REFILLING ARRANGEMENT FOR FIRE FIGHTING.	UT
5) FIRE EXTINGUISHER & (W/O TYPE IS MARKED)	FE
6) MANUAL CALL POINT	MC
7) ILLUMINATED EXIT DIRECTIONAL SIGN	ED
8) SIAMERE CONNECTION	SC
9) P.A SYSTEM	PA
10) EMERGENCY LIGHTING SYSTEM	EL
11) SPRINKLER	SP

PLOT DETAILS .
 PROPOSED RESIDENTIAL BUILDING FOR ASHRIWAD ENGICON PVT. LTD. THROUGH ITS DIRECTOR SMT. MAMTA SINHA W/O AJAY KUMAR SINGH AT MAUZA - SHEIKHPUR A MOSUME CHAKASHO THANA - RAMKRISHNA NAGAR THANA NO.-111 PLOT NO.-7 KHATA NO.-149 TAUKI-2/176C LAKHRAJ DIST.-PATNA.

NORTH	SCALE 1:100/1:200	DWG NO. 1599
Ashriwad Engicon Pvt. Ltd. गौरी सिन्हा Director AEPANAN 11 COA Regd No. C/2/11/17 (Enginering) No. B. 11/17		
SIGN. OF OWNER	SIGN. OF ARCHT	

Plan Number - 1599
 वर्षी राणी
 मुखिया
 काम पदावत काली लक्ष्मी
 1985-नवरात्र (काली)
 पृष्ठ-16

वर्षा रानी

मुखिया

पंचायत - कनौजी कछुआड़ा, प्रखण्ड-सम्पतचक, जिला-पटना

पत्रांक : 2932

संज्ञा नं० 1599

दिनांक : 23.04.2016...

सीमती ममता सिंह पति-श्री अजय कुमार सिंह द्वारा आशुवाड़
रजिस्ट्रार प्रा० लि० का निर्माण किया जा रहा है। इसका
खता नं० 149 खसरा नं० 7 है। जी. नं० 21/76C LAHARRAT
मौजा खैरपुर में निर्माण करना चाहते हैं। जो कि ग्राम पंचायत
कनौजी कछुआड़ा के अन्तर्गत आता है। भवन निर्माण का
पञ्चशा विद्या पंचायती राज के नियमोंनुसार है। अतः भवन
निर्माण पञ्चशा की स्वीकृति दी जानी है।

वर्षा रानी
मुखिया 1599

ग्राम पंचायत कनौजी कछुआड़ा

प्रखण्ड-सम्पतचक, पटना-16